


Beacon 22 Bouy

REVISIONS

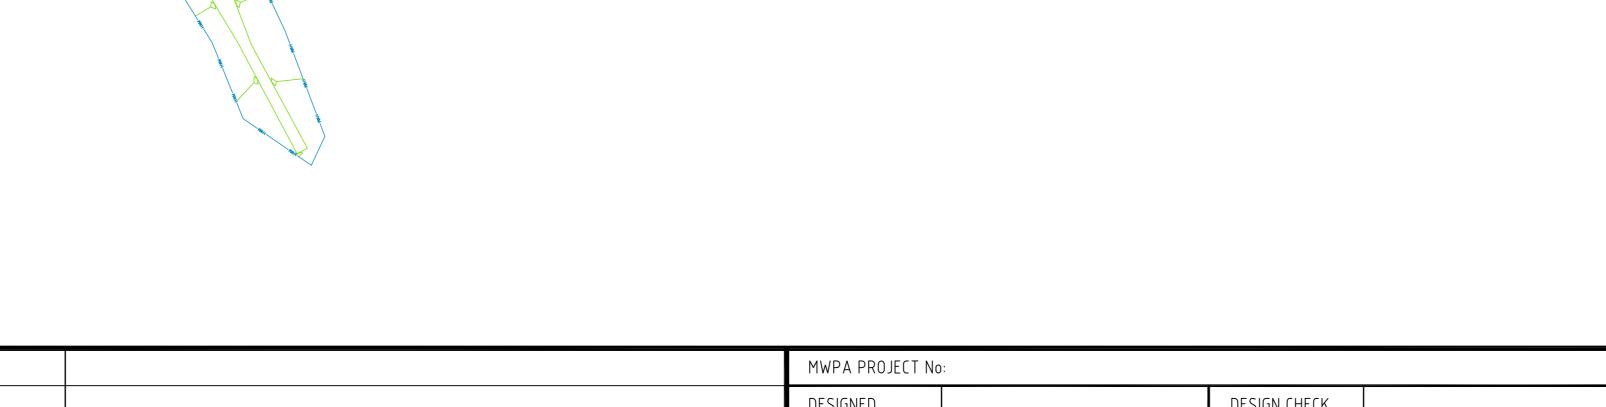

contract with which it was issued.

							MWPA PRUJELT NO:			
							DESIGNED		DESIGN CHECK	
							DRAWN	COMPILED	CHECKED	R. FERSTAT
							ENGINEER		APPROVED	I. MCLEOD
G	20.12.24	ISSUED FOR REFERENCE	RF	IM	010-G-0357	FEATURES AND SERVICES KEY PLAN AND INDEX	This drawing and all the information thereon remains the property of the Mid West Ports Authority and shall be returned			
REV	DATE	DESCRIPTION	DRN	APP	DRAWING No.	DRAWING TITLE	on demand. It is issued on the condition that, except with written permission, it must not be reproduced, copied or communicated to any other party, nor used for any other purpose than that stated on the particular order, enquiry, or			
								' 1 7'		

REFERENCE DRAWINGS

MID WEST PORTS

	GERALDTON PORT	
	PORT INFRASTRUCTURE, HARBOUR AND SURROUNDS	
	FEATURES AND SERVICES	
	IDENTIFICATION MAP 33 OF 34	
_	DDC H	۰

MID WEST PORTS AUTHORITY 298 Marine Terrace, GERALDTON 6530

Tel: +61 8 9964 0520 www.midwestports.com.au

A1 - 1:500

DRG. No. 010-G-0390